

ELECTRICAL LEGEND


\$ A.C. TOGGLE TYPE SWITCH, 120-277VAC, 20A, 42" AFF.
 Ⓢ DUPLEX RECEPT. - 3 WIRE GROUNDING TYPE, 100V, 15A, AS REQ. 18" AFF.
 Ⓢ A DUPLEX RECEPTACLE AS ABOVE WITH AFC FAULT CIRCUIT INTERRUPTER
 Ⓢ DF1 DUPLEX RECEPTACLE AS ABOVE WITH GROUND FAULT CIRCUIT INTERRUPTER
 Ⓢ UP DUPLEX RECEPTACLE AS ABOVE, WEATHERPROOF, 18" AFF.
 Ⓢ 220 DUPLEX RECEPTACLE AS ABOVE - 3 WIRE GROUNDING TYPE, 220V.
 ☒ FAN / LIGHT CORNER
 ☒ 48" x 4 TUBE - FLUORESCENT FIXTURE, SURFACE MOUNTED
 ☒ SURFACE MOUNTED INCANDESCENT LIGHT
 Ⓢ EXTERIOR DOWNLIGHT, SOFT RECEASED
 Ⓢ INTERIOR DOWNLIGHT, CEILING RECEASED
 Ⓢ INTERIOR DOWNLIGHT, CEILING RECEASED WITH PIVOTING EYEBALL TRIM
 Ⓢ WALL SCONCE
 Ⓢ CHANDELIER
 Ⓢ EXTERIOR SOFT MOUNTED FLOOD LIGHT
 Ⓢ INTERIOR CEILING FAN
 Ⓢ EXTERIOR CEILING FAN
 Ⓢ ELECTRICAL PANEL SEE PLANS FOR AMPERAGE
 Ⓢ ELECTRICAL METER w/ UNDERGROUND SERVICE
 Ⓢ WIRE
 Ⓢ EXHAUST FAN
 Ⓢ PENDANT LIGHTING
 Ⓢ 18" FLUORESCENT SURFACE MOUNTED FIXTURE
 Ⓢ 2 TONE ELECTRONIC CHIME - BUTTON ACTIVATED
 Ⓢ DB - BACKLITE BUTTON SWITCH FOR CHIMES
 Ⓢ SD - SMOKE DETECTOR w/ BATTERY BACKUP

DOOR SCHEDULE

- 1 2'-6" x 8'-0" x 1 1/2" (PAIR) QUONER TO SELECT (SEE ELEV.)
- 2 2'-0" x 6'-8" x 1 3/8" 6 PANEL MASONITE INTERIOR
- 3 3'-0" x 6'-8" x 1 3/4" FULL FRENCH METAL INSUL. EXT.
- 4 2'-4" x 6'-8" x 1 3/8" 6 PANEL MASONITE INTERIOR
- 5 3'-0" x 6'-8" x 1 3/8" 6 PANEL MASONITE INTERIOR
- 6 3'-0" x 6'-8" x 1 3/4" 6 PANEL METAL INSULATED
- 7 3'-0" x 8'-0" x 1 3/4" (PAIR) FULL FRENCH METAL INSUL. EXT.
- 8 1'-6" x 6'-8" x 1 3/8" paneled masonite interior
- 9 2'-8" x 6'-8" x 1 3/8" 6 PANEL MASONITE INTERIOR
- 10 2'-0" x 8'-0" x 1 3/8" (PAIR) FULL FRENCH WOOD INTERIOR
- 11 2'-4" x 6'-8" x 1 3/8" 6 PANEL MASONITE INTERIOR - POCKET
- 12 3'-0" x 6'-8" x 1 3/8" 6 PANEL MASONITE INTERIOR - POCKET

WINDOW SCHEDULE

- A 2'-6" x 6'-0" SINGLE HUNG - VINYL - INSULATED
- B 2'-6" x 4'-0" FIXED GLASS - VINYL - INSULATED
- C 2'-6" x 6'-0" (PAIR) SINGLE HUNG - VINYL - INSULATED
- D 2'-0" x 4'-0" SINGLE HUNG - VINYL - INSULATED
- E 2'-0" x 3'-0" SINGLE HUNG - VINYL - INSULATED
- F 2'-6" x 6'-0" (TRIPLE) SINGLE HUNG - VINYL - INSULATED
- G 2'-0" x 3'-0" (PAIR) SINGLE HUNG - VINYL - INSULATED
- H 2'-6" x 5'-0" SINGLE HUNG - VINYL - INSULATED
- I 2'-6" x 6'-0" SINGLE HUNG - VINYL - INSULATED w/ 12" TRANSOM
- J 2'-6" x 5'-0" (TRIPLE) SINGLE HUNG - VINYL - INSULATED

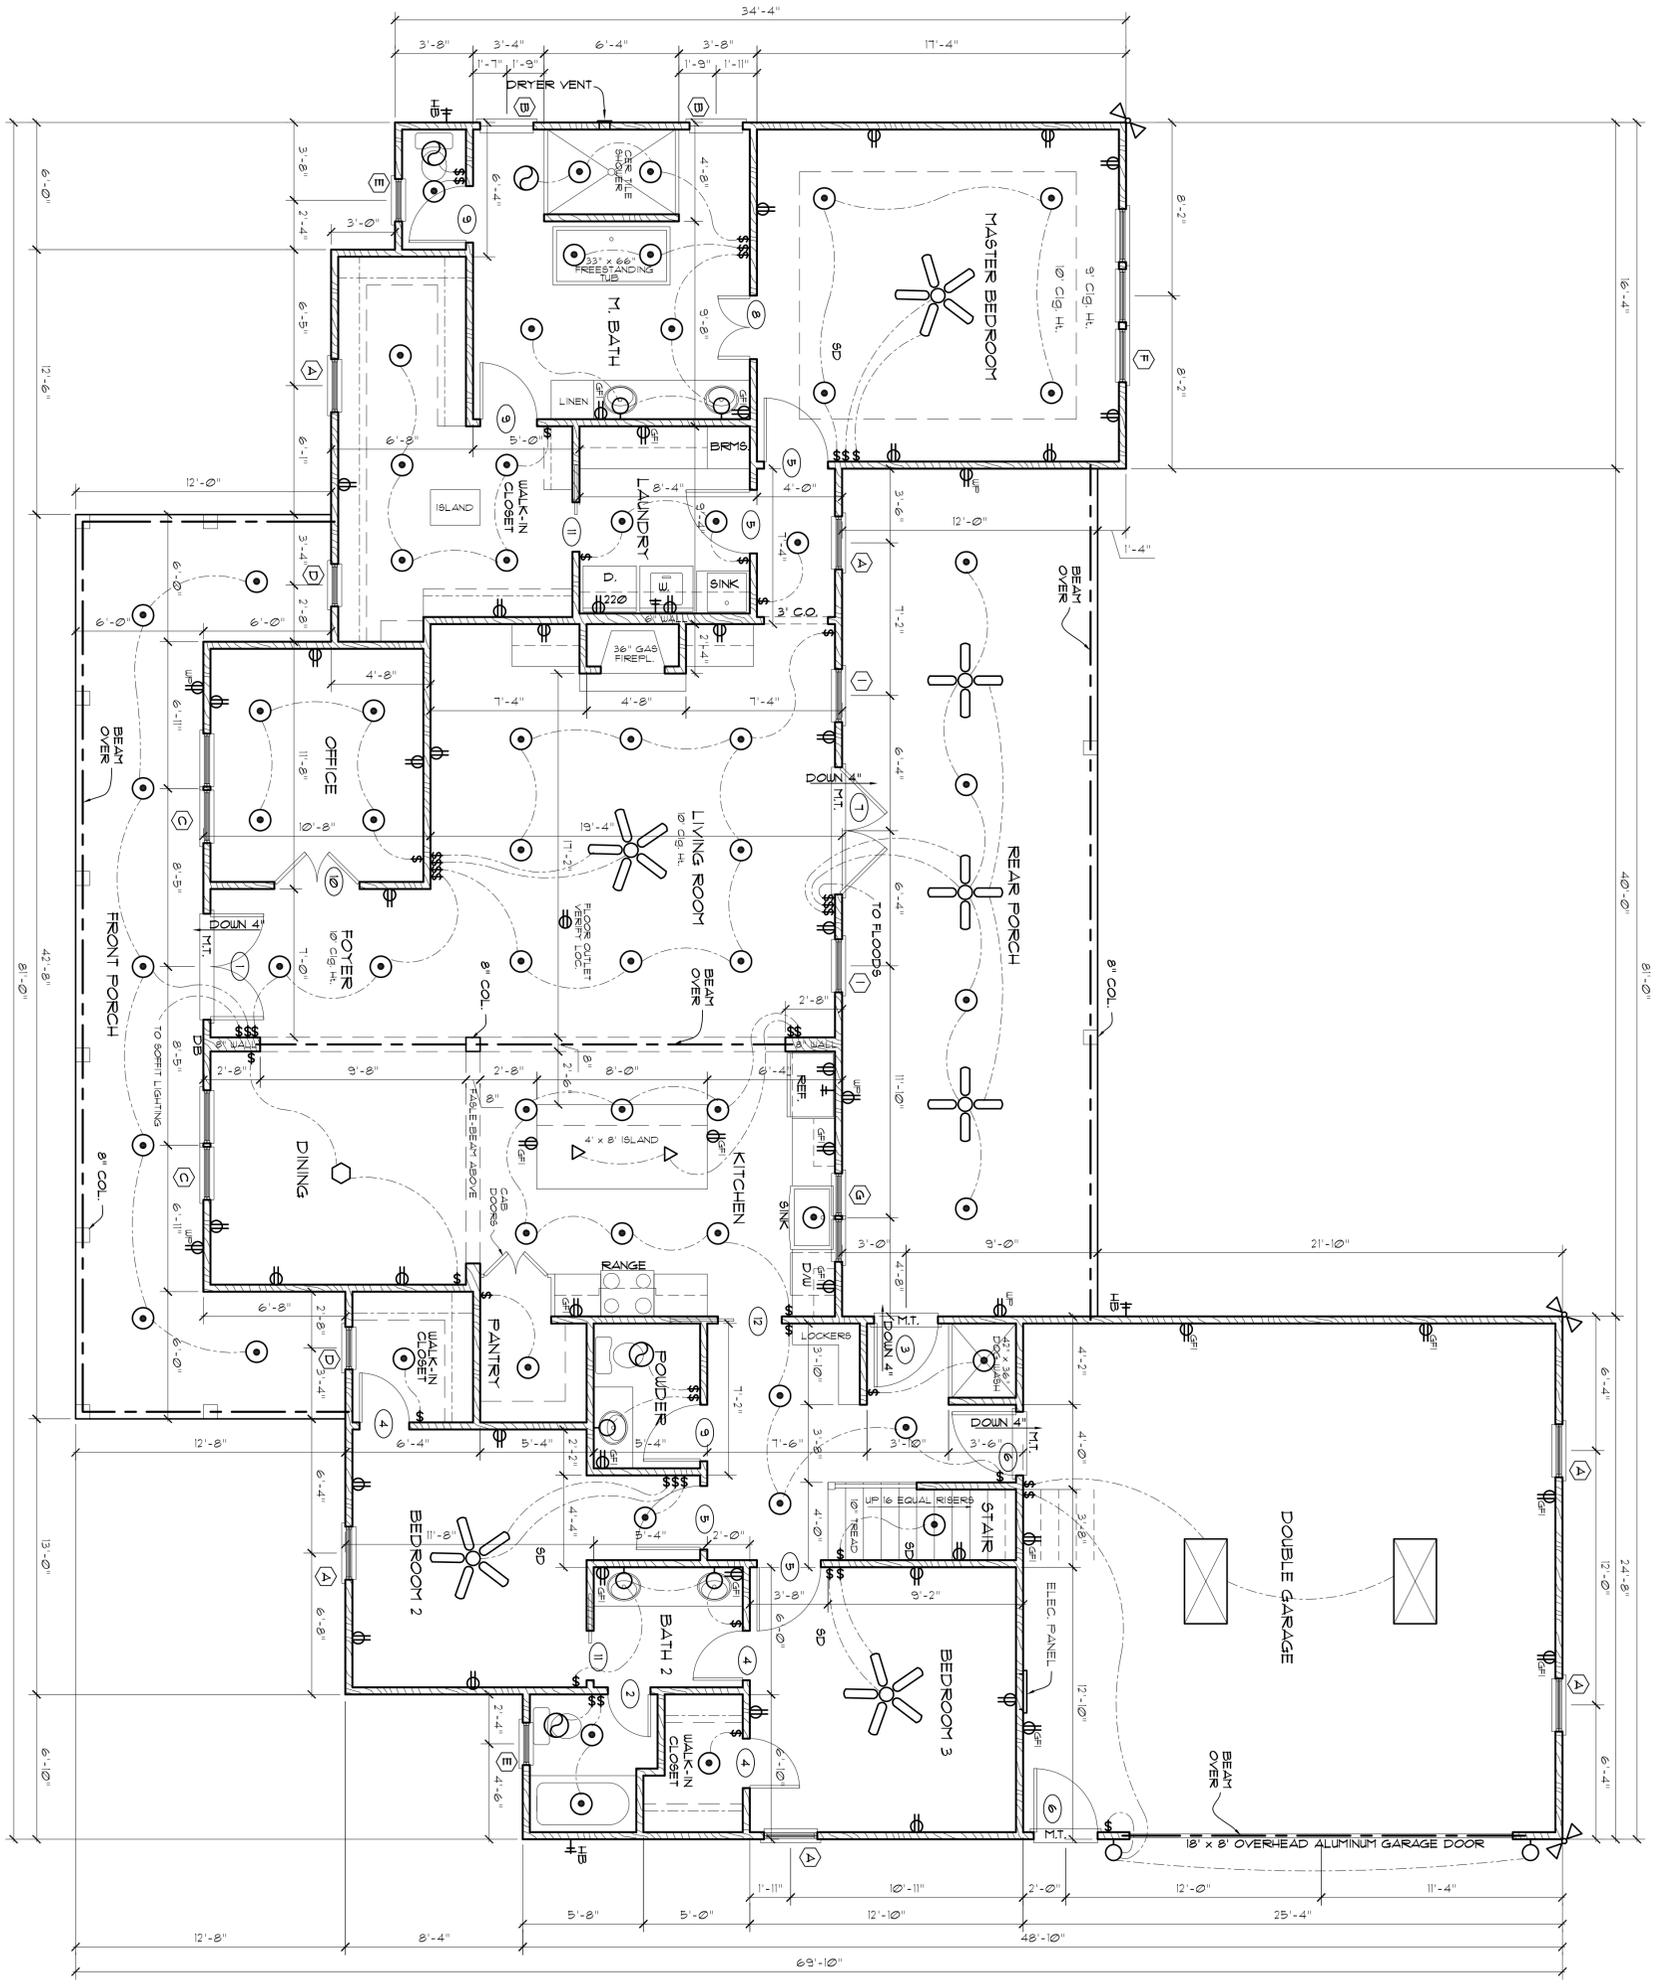

SQUARE FOOTAGE TOTALS:

- MAIN FLOOR HEATED SQUARE FOOTAGE = 2463 SQ. FT.
- BOUNDS ROOM HEATED SQUARE FOOTAGE = 326 SQ. FT.
- TOTAL HEATED SQUARE FOOTAGE = 2789 SQ. FT.
- GARAGE SQUARE FOOTAGE = 624 SQ. FT.
- FRONT PORCH SQUARE FOOTAGE = 332 SQ. FT.
- REAR PORCH SQUARE FOOTAGE = 480 SQ. FT.
- TOTAL UNDER ROOF = 4225 SQ. FT.

FLOOR PLAN - MAIN FLOOR

SCALE: 1/4" = 1'-0"

** SET WINDOWS @ 7'-4" AFF. UNLESS OTHERWISE NOTED **

CONTRACTOR TO VERIFY LOCATION OF ALL PHONE JACKS AND CABLE TV OUTLETS PRIOR TO INSTALLATION
 NOTE:
 THE DESIGNER ASSUMES NO LIABILITY FOR THE ACCURACY OF THE INFORMATION PROVIDED HEREIN AND DISCLAIMS ANY AND ALL WARRANTIES AND REPRESENTATIONS, EXPRESS OR IMPLIED, INCLUDING BUT NOT LIMITED TO, THE MERCHANTABILITY AND FITNESS FOR ANY PARTICULAR PURPOSE OF THE INFORMATION PROVIDED HEREIN.
 ALL RIGHTS RESERVED. NO PART OF THIS DOCUMENT MAY BE REPRODUCED OR TRANSMITTED IN ANY FORM OR BY ANY MEANS, WITHOUT WRITTEN PERMISSION FROM VAUGHN DESIGN.
 THE DESIGNER ASSUMES NO LIABILITY FOR THE ACCURACY OF THE INFORMATION PROVIDED HEREIN AND DISCLAIMS ANY AND ALL WARRANTIES AND REPRESENTATIONS, EXPRESS OR IMPLIED, INCLUDING BUT NOT LIMITED TO, THE MERCHANTABILITY AND FITNESS FOR ANY PARTICULAR PURPOSE OF THE INFORMATION PROVIDED HEREIN.